


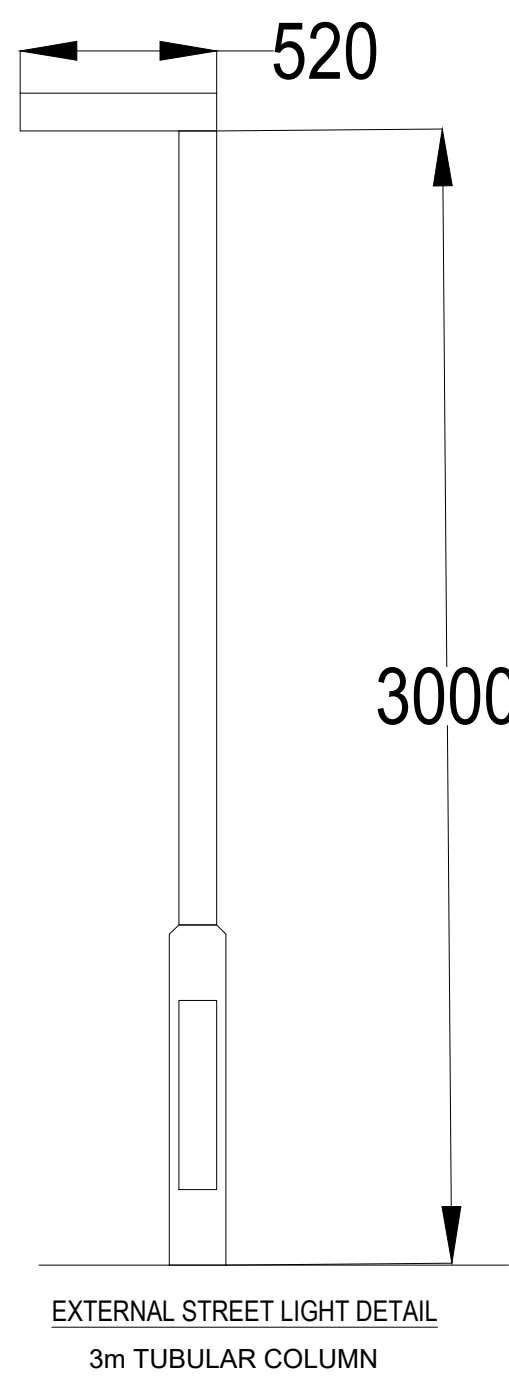




Specification Text

The VIVA-CITY Pro shall be manufactured from die-cast aluminium and powder coated in RAL 7016 Marine Grade finish. It shall have a power output ranging between 10 - 180W, with an efficacy of 96 - 150lm/W. The luminaire shall deliver 662 - 24,840 luminaire lumens. It shall have a fully programmable DALI driver. Available in 2700K or 4000K, the luminaire shall be IK08 and IP68 rated. It shall have photocell options available.

For DarkSky Specifications, the luminaire shall produce a CCT of 2700K.

Specification

Weight: 5.1 - 10.5 kg
Windage: 0.06 - 0.09 m²
Material: Die-cast Aluminium
Paint Finish: RAL7016 Anthracite Grey
Embodied Carbon: 89 - 182 kg CO²e

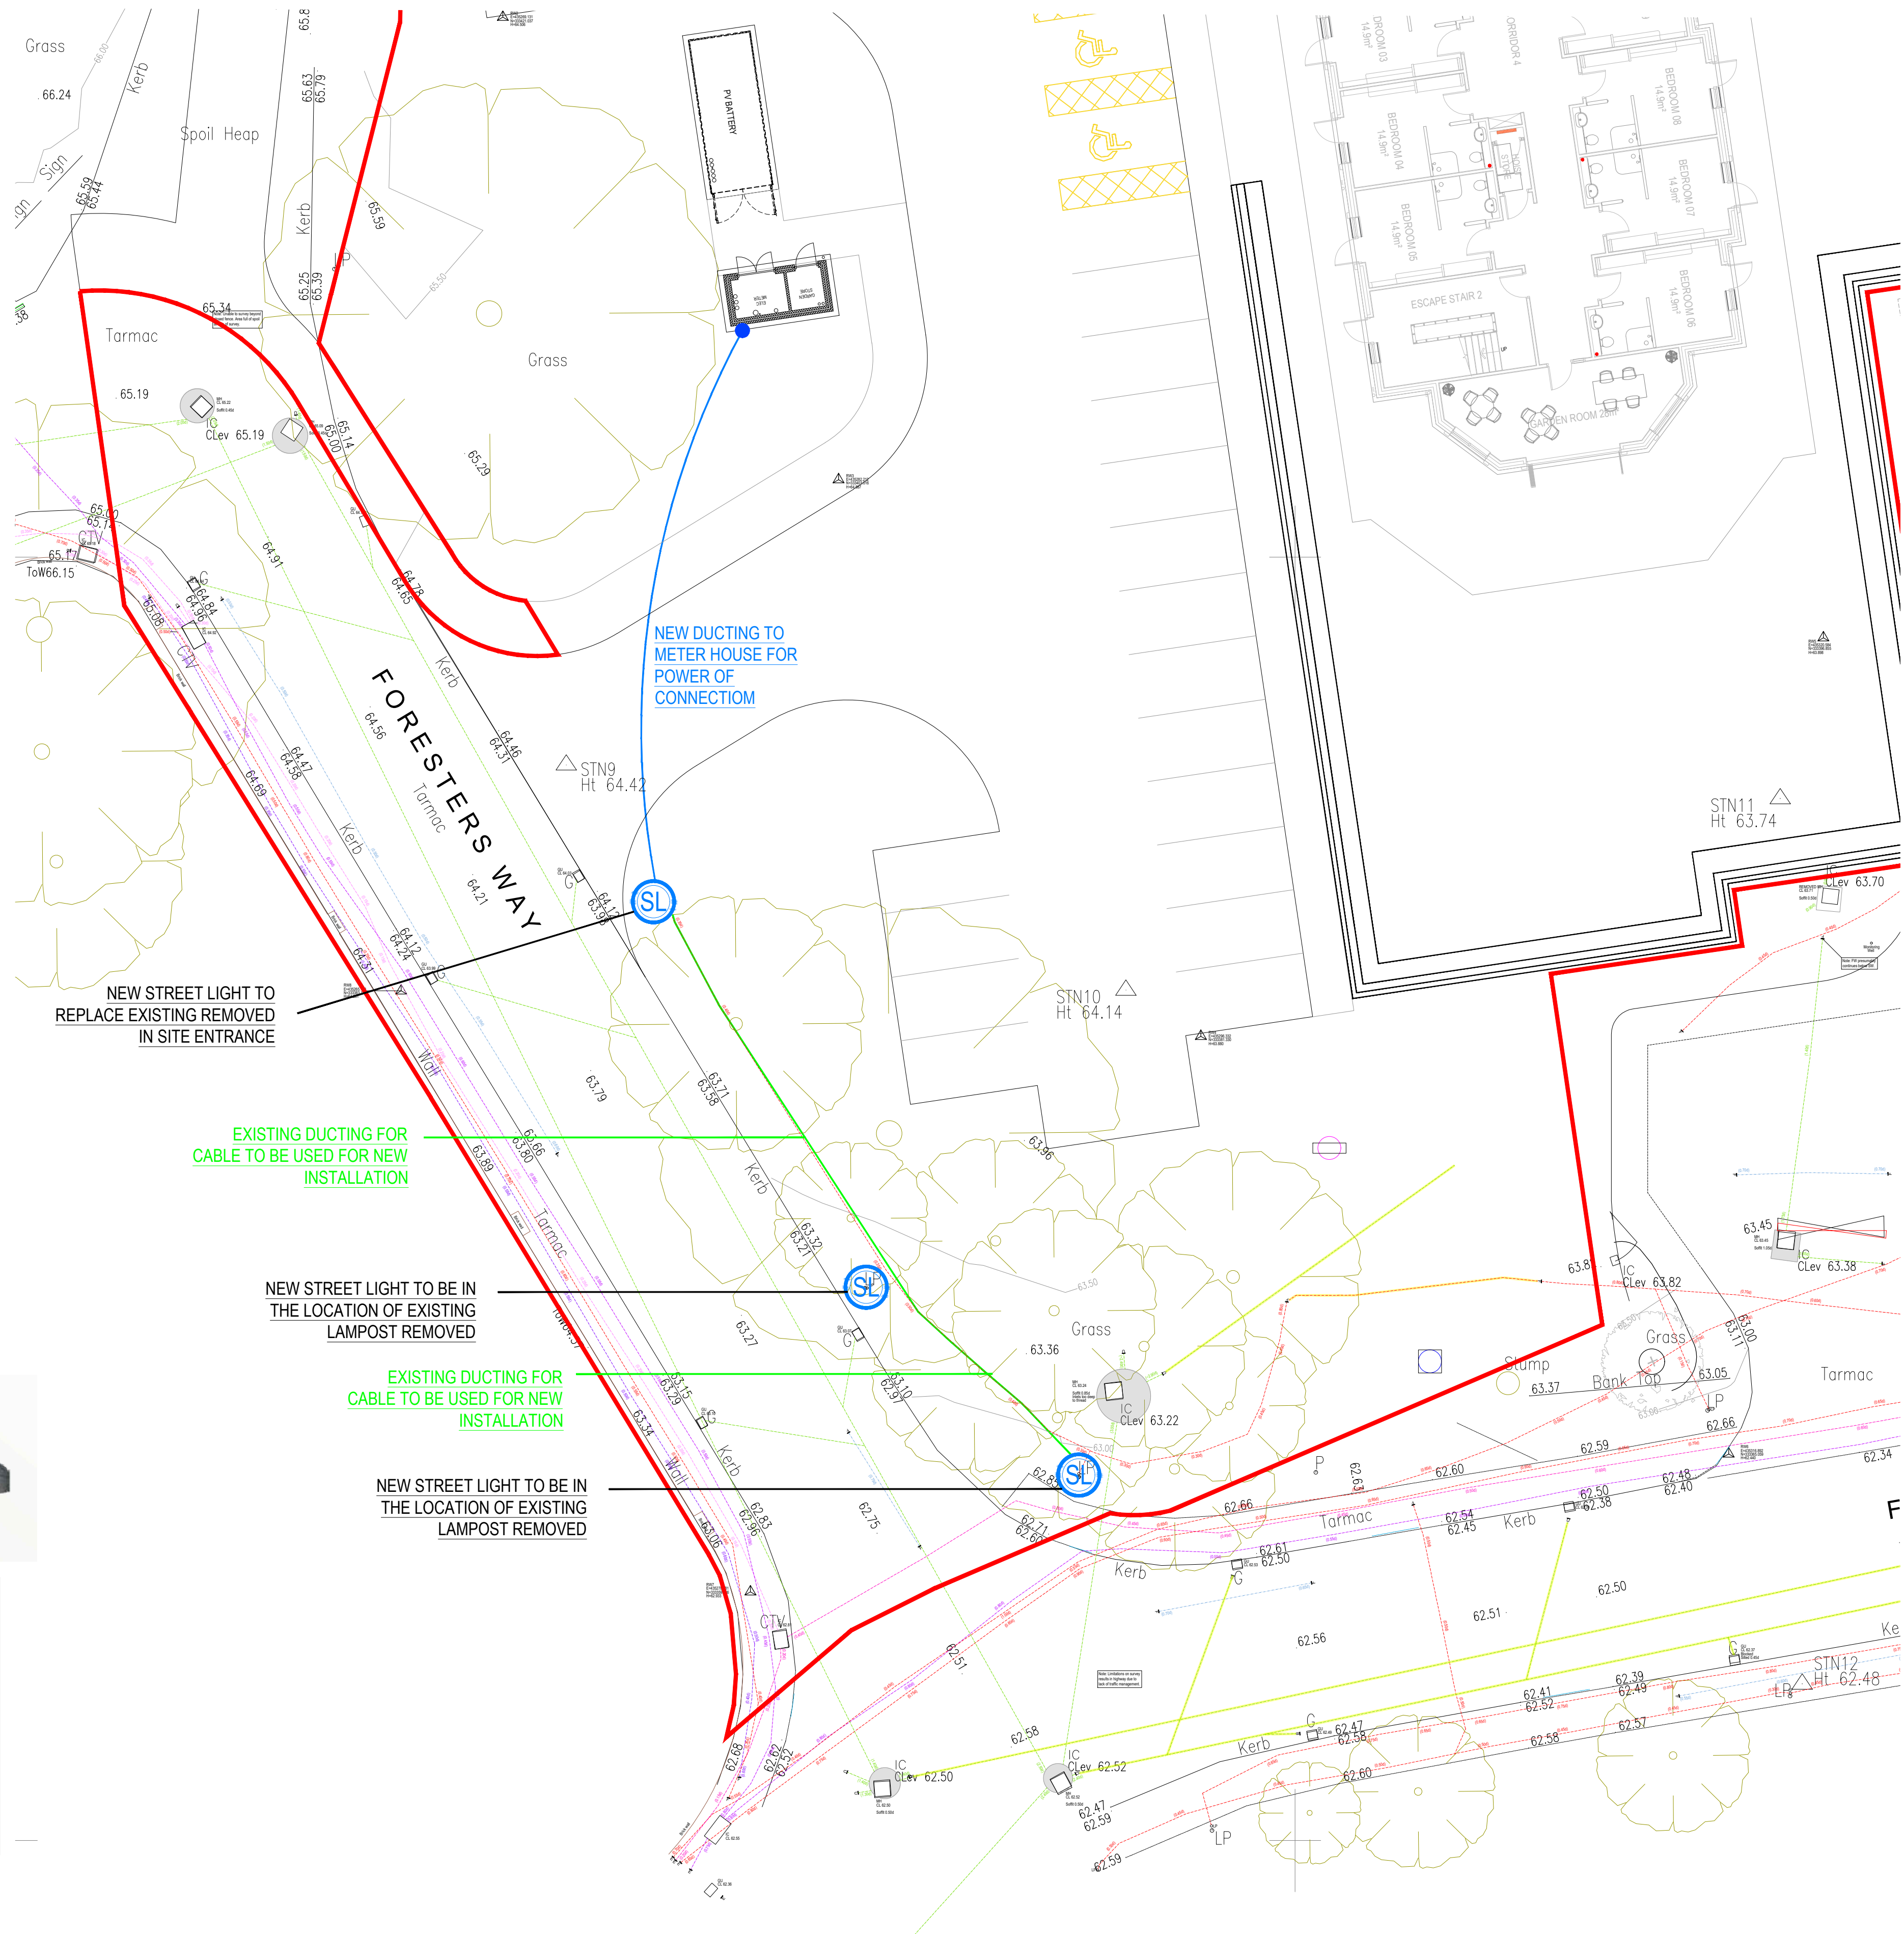

REV	DATE	DETAILS OF AMENDMENTS	DRAWN
LNT Construction Unit 2, Helios 47, Isabella Road, Garforth, Leeds, LS25 2DY Tel: 0113 385 3850			
SITE		Foresters Way, Derby, DE23 8AG	
TITLE		EXTERNAL STREET LIGHTING PLAN	
SCALE	1:150	DRAWN	JC
DRAWING NO.		REVISION	
E-105		-	
DRAWING STATUS		CONSTRUCTION	